
 


FILE NAME: S:\MWA-056\NHA\2.2 Final Design\CADD\READING\Civil\7471_C-18.dwg LAYOUT NAME: C-18 PLOTTED: Friday, September 11, 2015 - 2:13pm USER: Bouahli_n

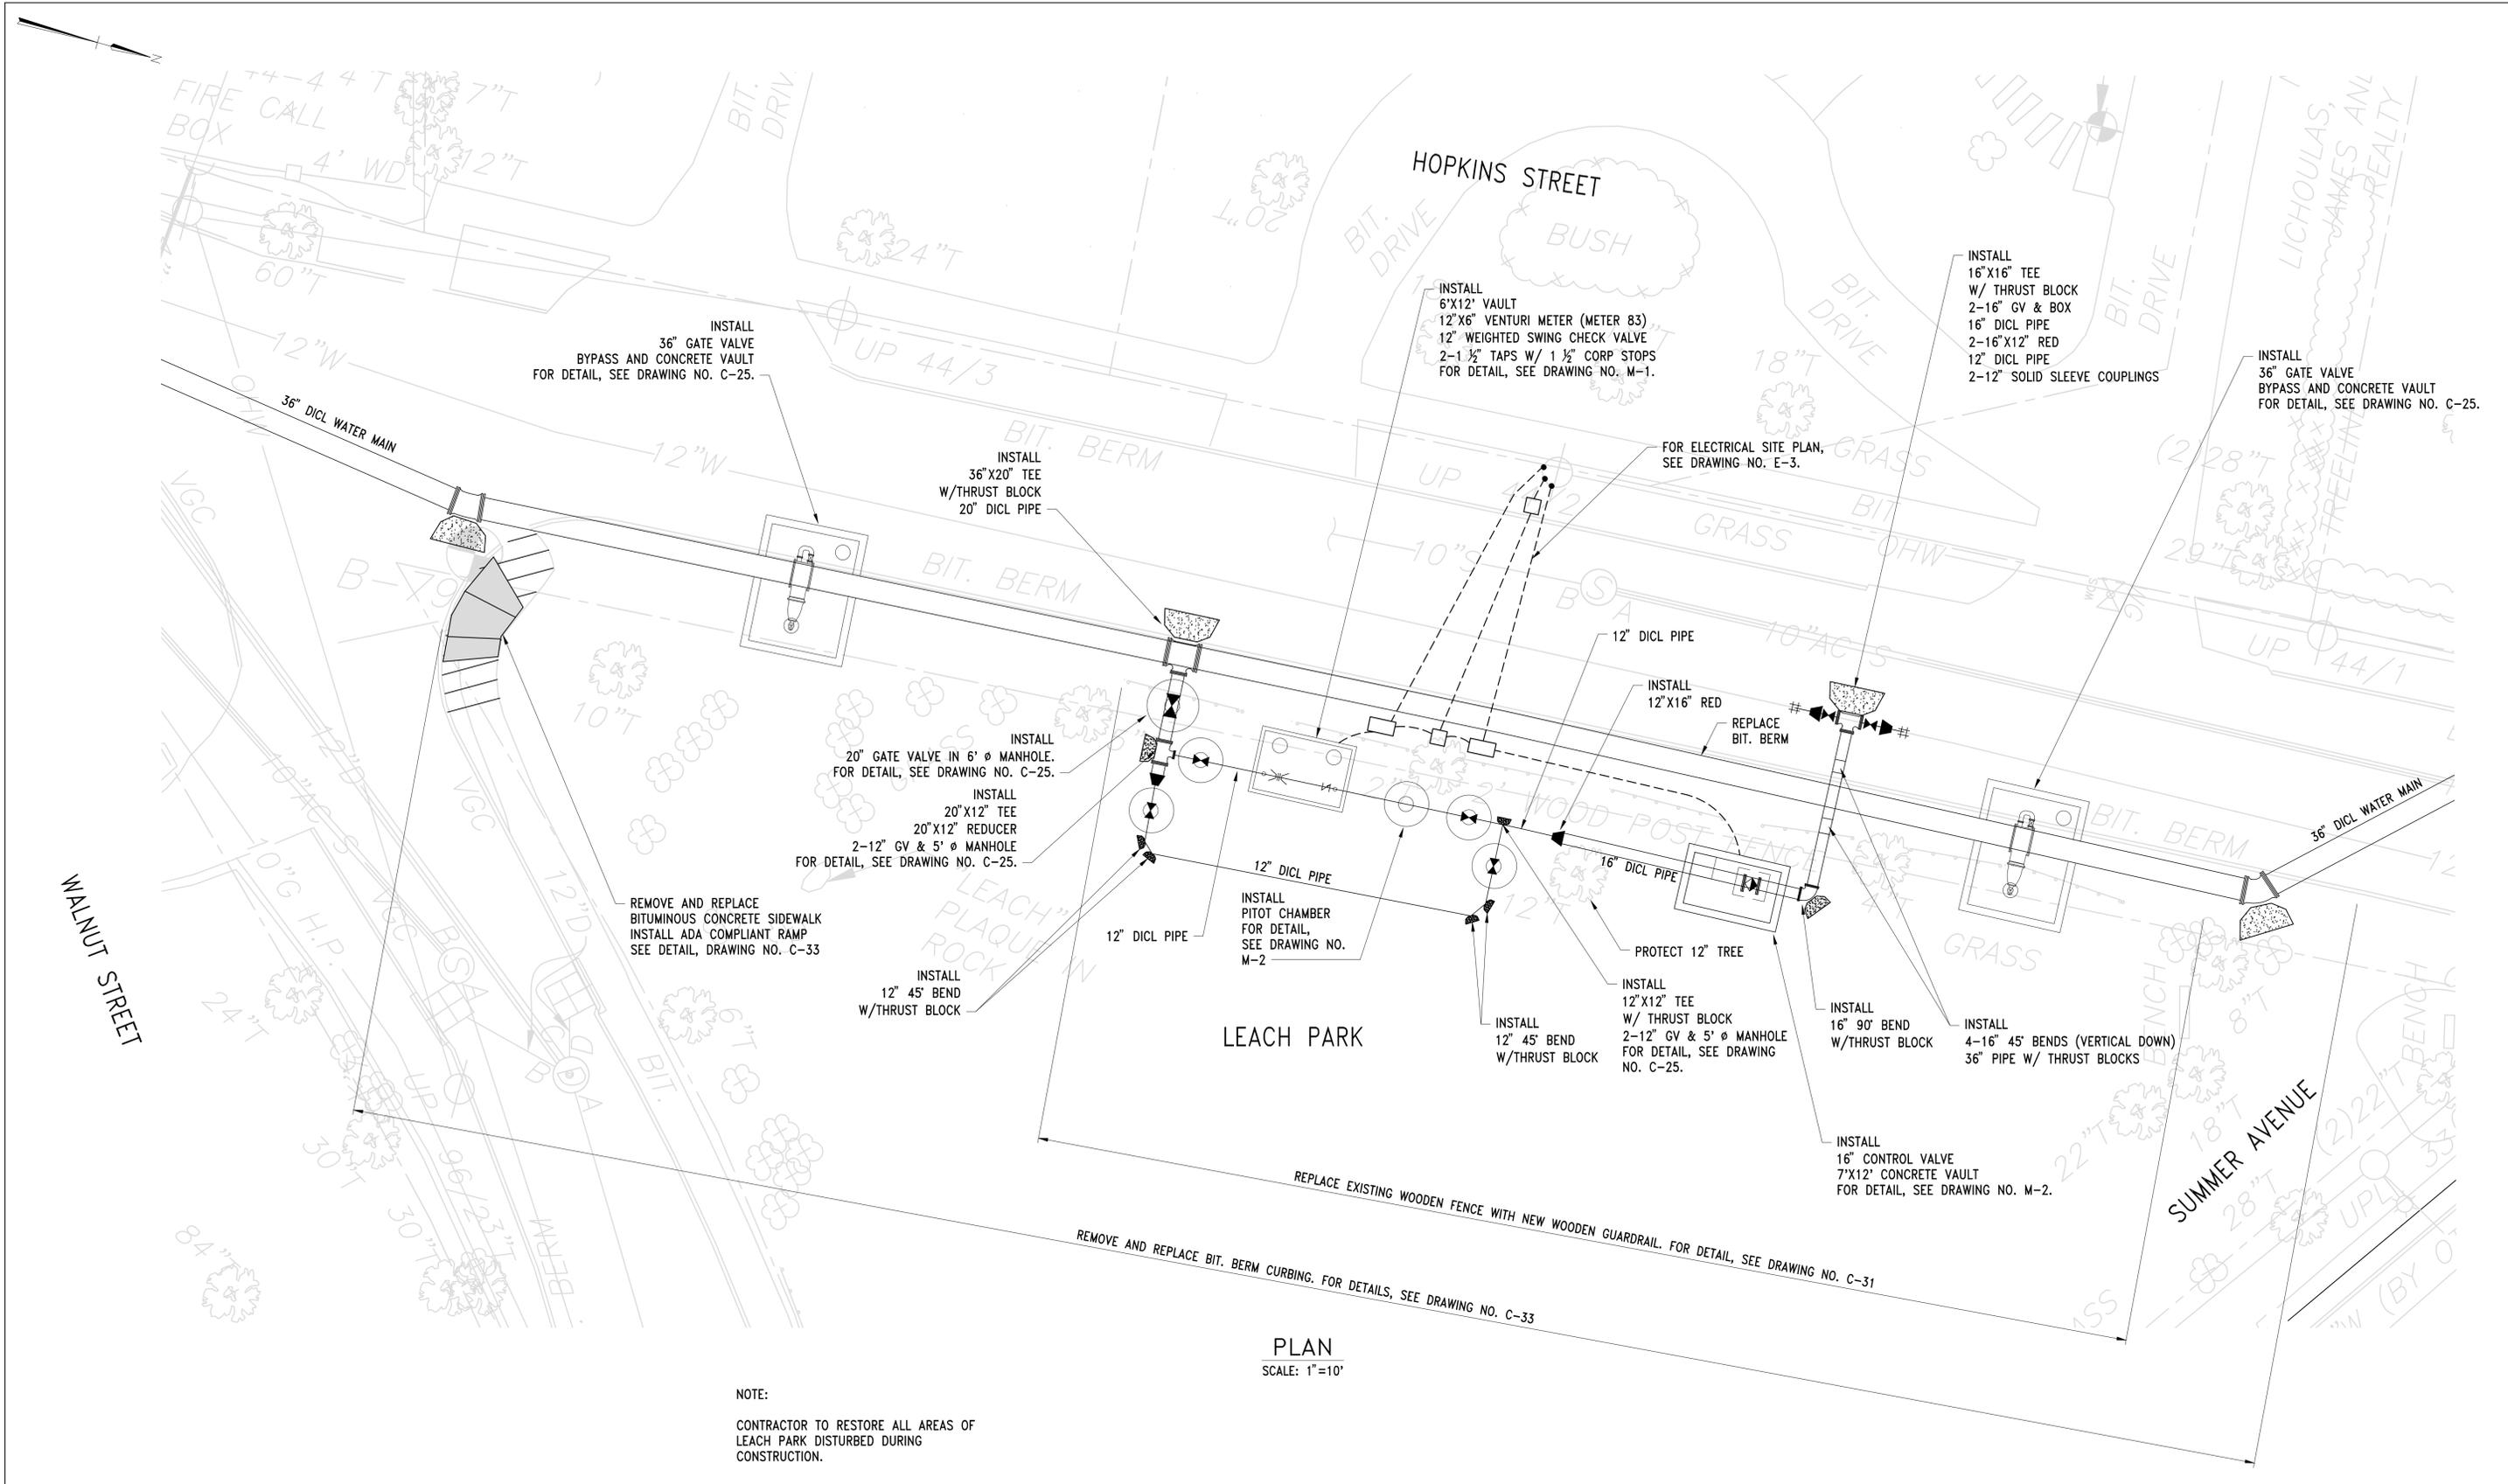


PLAN
SCALE: 1"=10'

NOTE:
CONTRACTOR TO RESTORE ALL AREAS OF LEACH PARK DISTURBED DURING CONSTRUCTION.



NO.	DATE	BY	CHK'D	REVISION

CONTRACT NO. :	7471	CAD FILE NO. :	7471_C-18.dwg
ACCESSION NO. :	701466	SECTION NO. :	110
DATE:	SEPTEMBER 2015	DESIGNED BY:	JJA
		DRAWN BY:	AMD
		CHECKED BY:	GAB/DPB
SCALE:	1"=10'	APPROVED BY:	DPB

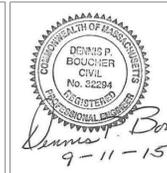

MASSACHUSETTS WATER RESOURCES AUTHORITY
PREPARED BY:
FAY, SPOFFORD & THORNDIKE
ENGINEERS • PLANNERS • SCIENTISTS
BURLINGTON, MA

NORTHERN INTERMEDIATE HIGH PIPELINE
SECTION 110
READING AND WOBURN
MWRA METER 83 - HOPKINS STREET
SITE PLAN
SITE PLAN

DRAWING NO.
C-18
24 OF 69