



FILE NAME: S:\WA-056 NHA\2.2 Final Design\CADD\READING\Civil\7471_C-1-C-8.dwg LAYOUT NAME: C-8 PLOTTED: Thursday, September 10, 2015 - 4:39pm USER: Baubhi_n

 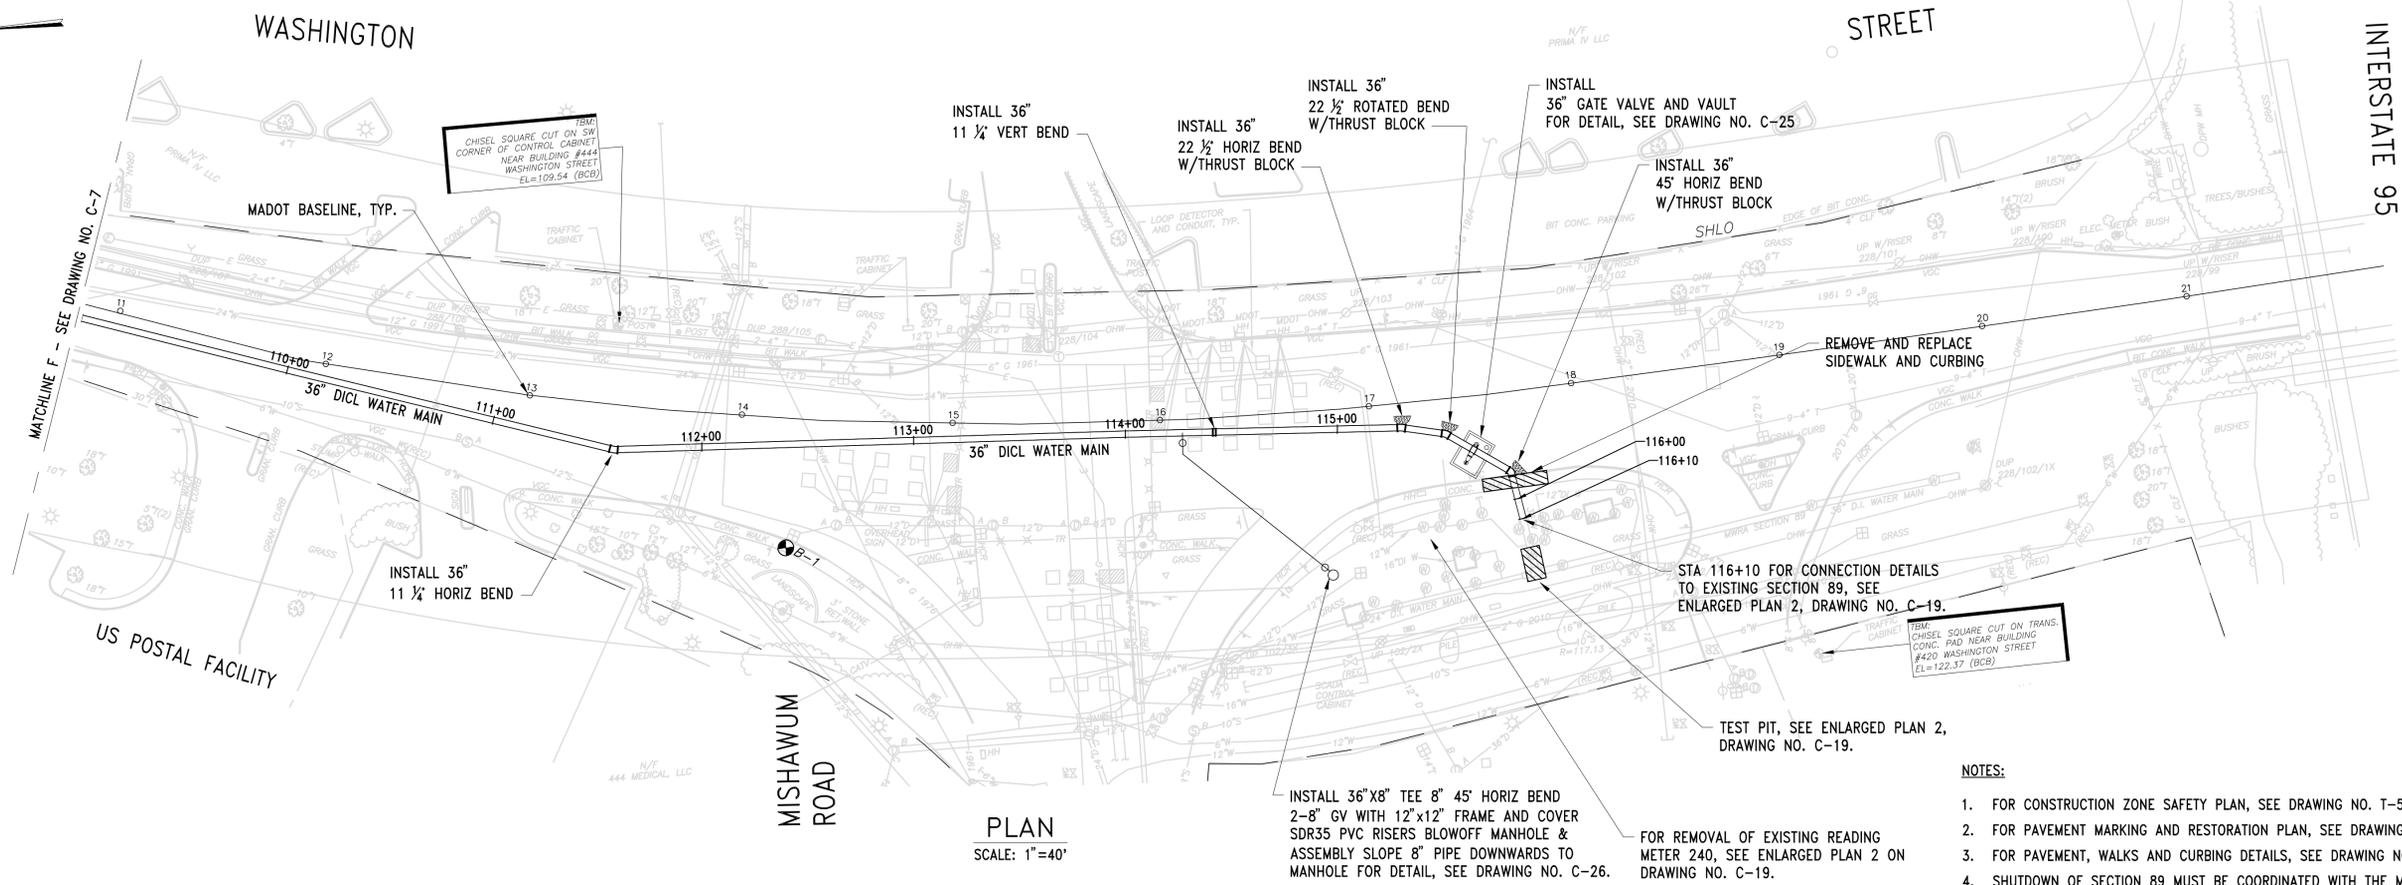


PLAN
SCALE: 1"=40'

- NOTES:
1. FOR CONSTRUCTION ZONE SAFETY PLAN, SEE DRAWING NO. T-5 AND T-6.
 2. FOR PAVEMENT MARKING AND RESTORATION PLAN, SEE DRAWING NO. C-23.
 3. FOR PAVEMENT, WALKS AND CURBING DETAILS, SEE DRAWING NO. C-32 AND C-33.
 4. SHUTDOWN OF SECTION 89 MUST BE COORDINATED WITH THE MWRA AT LEAST 6 WEEKS IN ADVANCE.
 5. NO SHUTDOWN OF SECTION 89 SHALL TAKE PLACE BETWEEN MAY 15 AND SEPTEMBER 15.
 6. THE MAXIMUM DURATION OF ANY SHUTDOWN OF SECTION 89 IS 8 HOURS AND MUST TAKE PLACE BETWEEN THE HOURS OF 9:00PM AND 5:00AM.
 7. FOR TRAFFIC SIGNAL MODIFICATIONS, SEE DRAWING NO. T-12. CONTRACTOR SHALL FURNISH AND INSTALL THE TRAFFIC VIDEO DETECTION SYSTEM PRIOR TO THE COMMENCEMENT OF WATER MAIN INSTALLATION IN THIS AREA.
 8. REFER TO SPECIFICATION SECTION 01015 FOR WORK HOUR RESTRICTIONS.

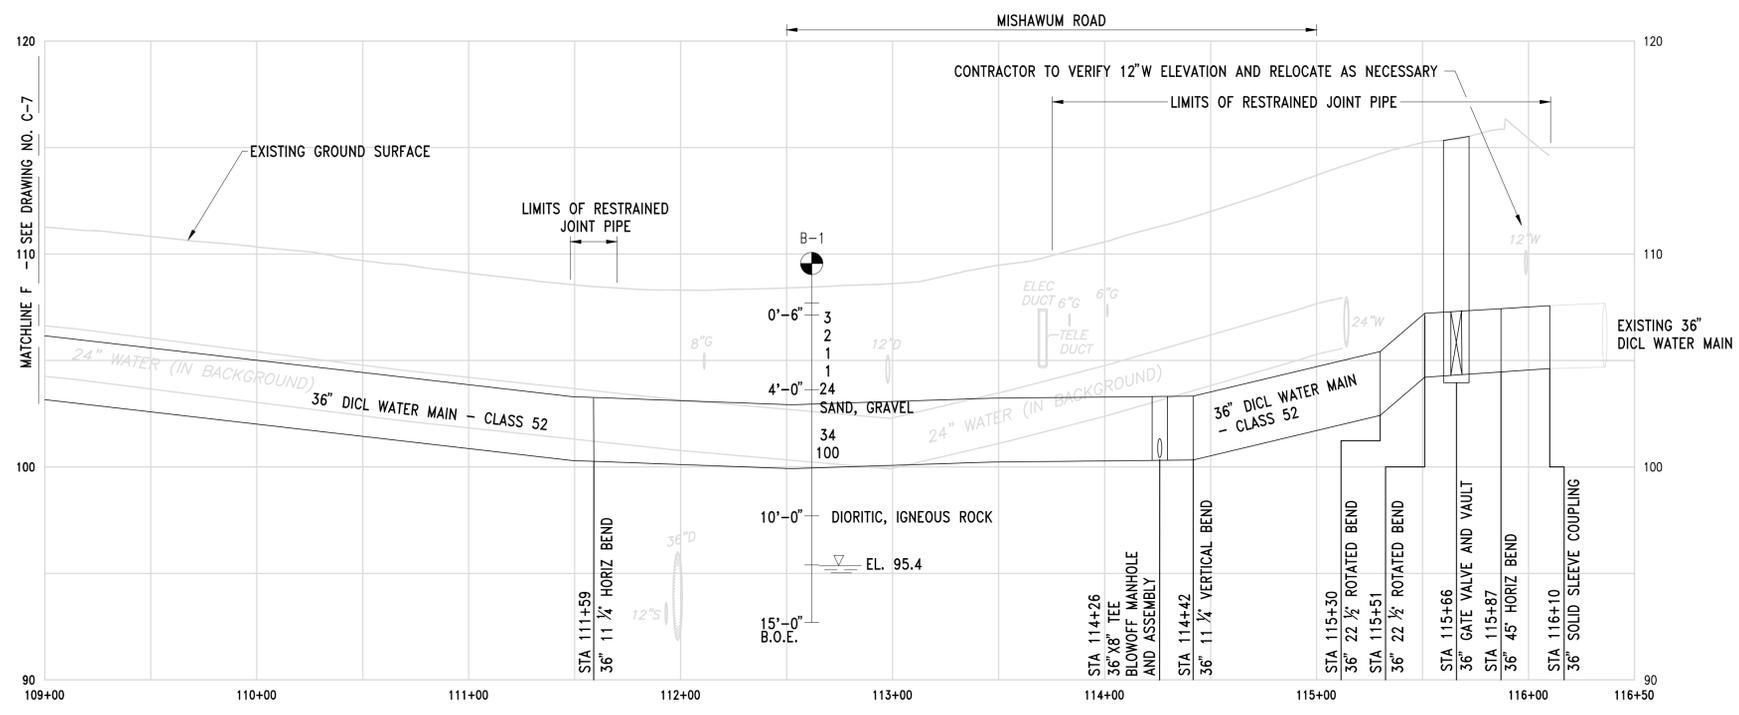


PROFILE
SCALE: HORIZ 1"=40'
VERT 1"=4'



NO.	DATE	BY	CHK'D	REVISION

CONTRACT NO.:	7471	CAD FILE NO.:	7471_C-1-C-8.dwg
ACCESSION NO.:	701456	SECTION NO.:	110
DATE:	SEPTEMBER 2015	DESIGNED BY:	NRB
SCALE:	AS SHOWN	DRAWN BY:	NRB
		CHECKED BY:	GAB/DPB
		APPROVED BY:	DPB

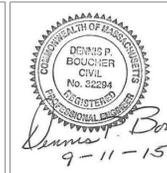

MASSACHUSETTS WATER RESOURCES AUTHORITY

PREPARED BY:

FST
100 YEARS

FAY, SPOFFORD & THORNDIKE
ENGINEERS • PLANNERS • SCIENTISTS
BURLINGTON, MA

NORTHERN INTERMEDIATE HIGH PIPELINE
SECTION 110
READING AND WOBURN

MWRA WATER MAIN PLAN AND PROFILE 8
WASHINGTON STREET (WOBURN)
STA. 109+00 TO STA. 116+50

DRAWING NO.
C-8

14 OF 69